



FLOOR PLAN

NOTES
DO NOT SCALE WORK TO FIGURED DIMENSIONS ONLY,
CONTRACTOR TO CHECK ALL DIMENSIONS.
ALL ERCORS AND OMMISSIONS TO BE REPORED TO THE ARCHITECT.

Kitchen

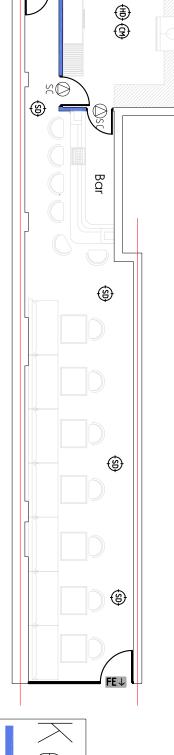

FIRE STRATEGY

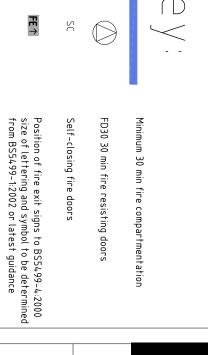

	Carbon monoxide detector to all kitchens adjacent final boilers position	Heat Detector TO KITCHEN (on independent circuit) interlinked where more than one provided	Smoke Detector (on independent circuit) interlinked where more than one provided	RICAL KEY:	Position of fire exit signs to BS5499-4:2000 size of lettering and symbol to be determined from BS5499-1:2002 or latest guidance	Self-closing fire doors	FD30 30 min fire resisting doors	Minimum 30 min fire compartmentation	
06	Job Number	Scale 1:100@A3		TITLE Floor Plans	Premise Licence	PROJECT	200b AI	ADDBESS.	
001	Drawing Number	Date Aug 2020					200b Alexandra Avenue, HA2 9BU		
	Revision	Drawn by KY					HA2 9BU		

ELECTRICAL KEY: